


10' POWER EASEMENT SOUTHERN CALIFORNIA EDISON CO. RECORDER SEPTEMBER 11, 1954 IN BOOK 37175, PAGE 19, DOC. NO. 2664

(E) CROWN CASTLE LEASE AREA

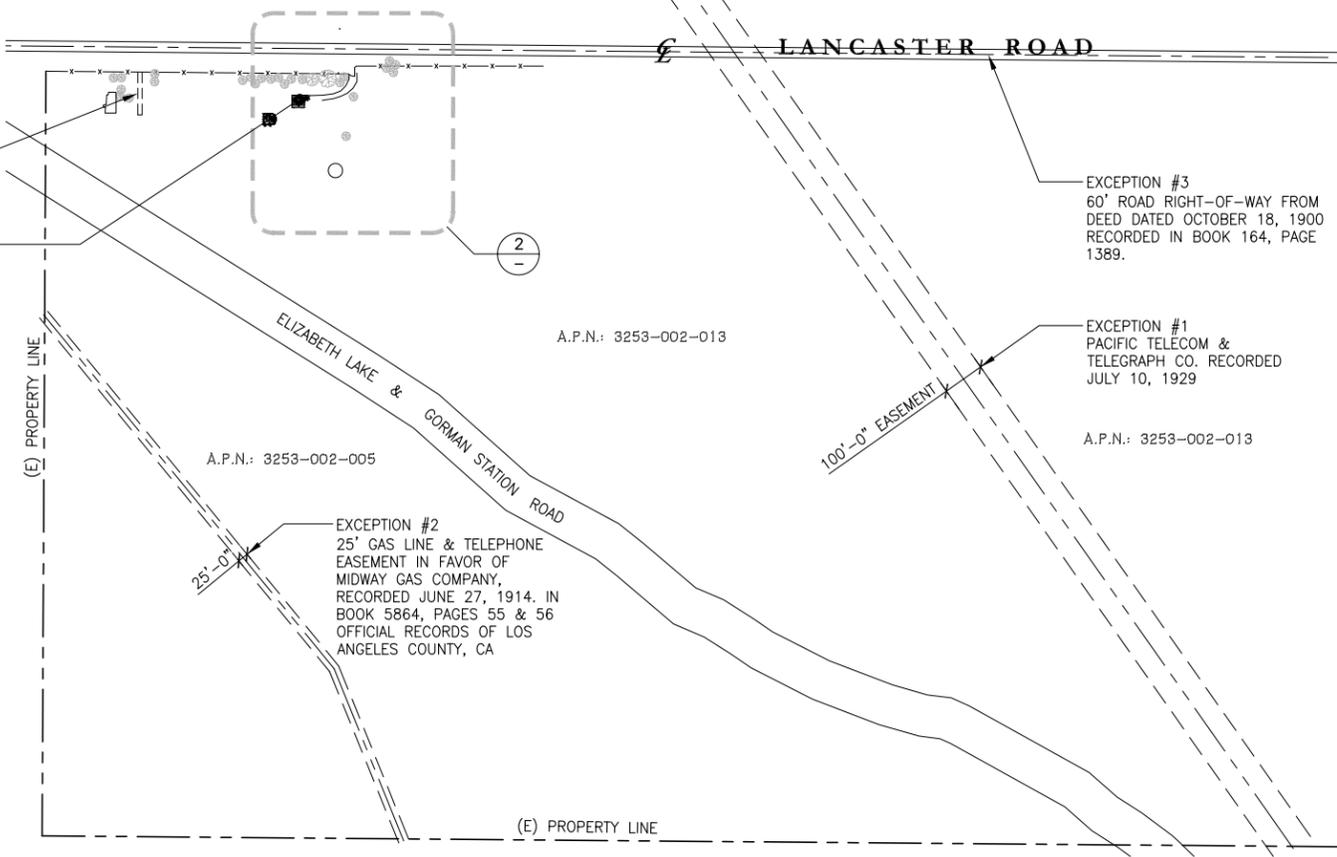

KEYNOTES

- 1 (E) GRAVEL BED
- 2 (E) ±8'-0" HIGH CHAINLINK FENCE
- 3 PROPOSED 'METROPCS' 9'-0" WIDE ACCESS GATE
- 4 (E) CONCRETE SLAB
- 5 (E) EQUIPMENT PAD
- 6 (E) POLE FOUNDATION
- 7 (E) CROWN CASTLE ±102'-0" HIGH MONOPOLE
- 8 (E) 'SPRINT' EQUIPMENT CABINET
- 9 (E) 'SPRINT' BATTERY
- 10 (E) 'SPRINT' METER/MAIN
- 11 (E) 'SPRINT' EGR/PPC TELCO PANEL
- 12 (E) 'SPRINT' CABLE BRIDGE
- 13 (E) 'SPRINT' GPS ANTENNA
- 14 (E) 'SPRINT' ANTENNAS, 2 PER SECTOR (4 ANTENNAS TOTAL)
- 15 (E) 'VERIZON' EQUIPMENT CABINET
- 16 (E) 'VERIZON' GENERATOR
- 17 PROPOSED 'METROPCS' UTILITY BOX ON (E) VERIZON' UTILITY RACK
- 18 PROPOSED 'METROPCS' METER/MAIN
- 19 (E) 'VERIZON' METER/MAIN
- 20 (E) SERVICE LIGHT
- 21 (E) 'VERIZON' ANTENNA (4) TOTAL (SHOWN DASHED FOR CLARITY)
- 22 PROPOSED 2'φ 'METROPCS' M.W. DISH, 2 TOTAL
- 23 PROPOSED 'METROPCS' EQUIPMENT CABINETS ON CONCRETE PAD
- 24 PROPOSED 'METROPCS' GPS ANTENNA ON ELEVATED COAX CABLE TRAY/ICE BRIDGE
- 25 PROPOSED 'METROPCS' (2) ANTENNA PER SECTOR (6 ANTENNAS TOTAL)
- 26 (E) 4'φ 'VERIZON' MICROWAVE DISH
- 27 PROPOSED 'METROPCS' ELEVATED COAX CABLE TRAY/ICE BRIDGE
- 28 PROPOSED 'METROPCS' SERVICE LIGHT
- 29 PROPOSED 'METROPCS' TELCO & PPC BOXES



DCI PACIFIC
A|E|C WORKS

ARCHITECTURE | ENGINEERING | CONSULTING
32 EXECUTIVE PARK | SUITE 110 | IRVINE | CA 92614
T 949 475.1000 | 949 475.1001 F



PROJECT IDENTIFICATION:

QUAIL LAKE
878021

33700 W. LANCASTER ROAD,
GORMAN, CA 93536


CURRENT ISSUE DATE:

06/25/12


ISSUED FOR:

RENEWAL

OVERALL SITE PLAN

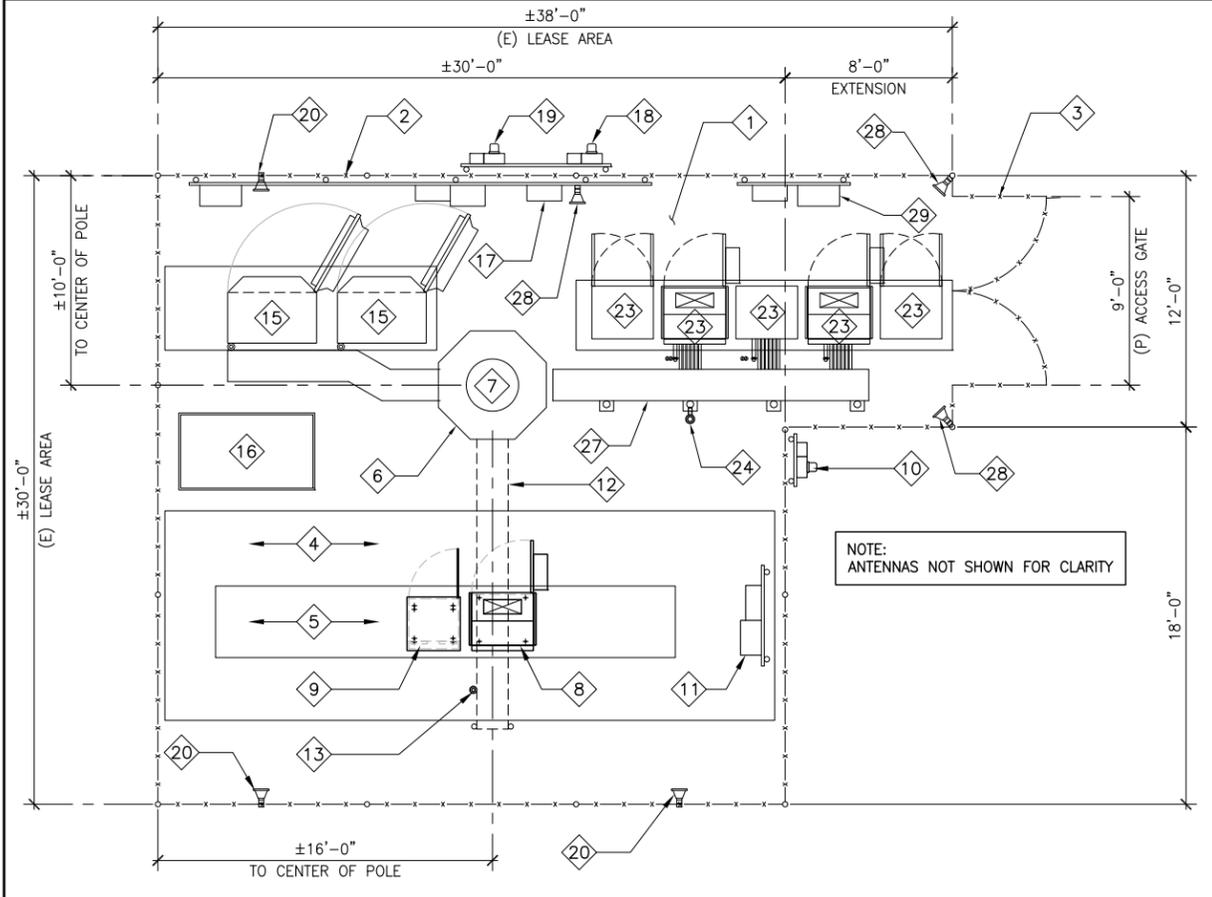

NOTE:
EXISTING 2'φ METROPCS MW DISH IS NOT VISIBLE IN THIS VIEW. IT IS BELOW EXISTING 4'φ 'VERIZON' MW DISH. -SEE ELEVATIONS ON SHEET A2 FOR VIEW OF EXISTING METROPCS 2'φ MW DISH

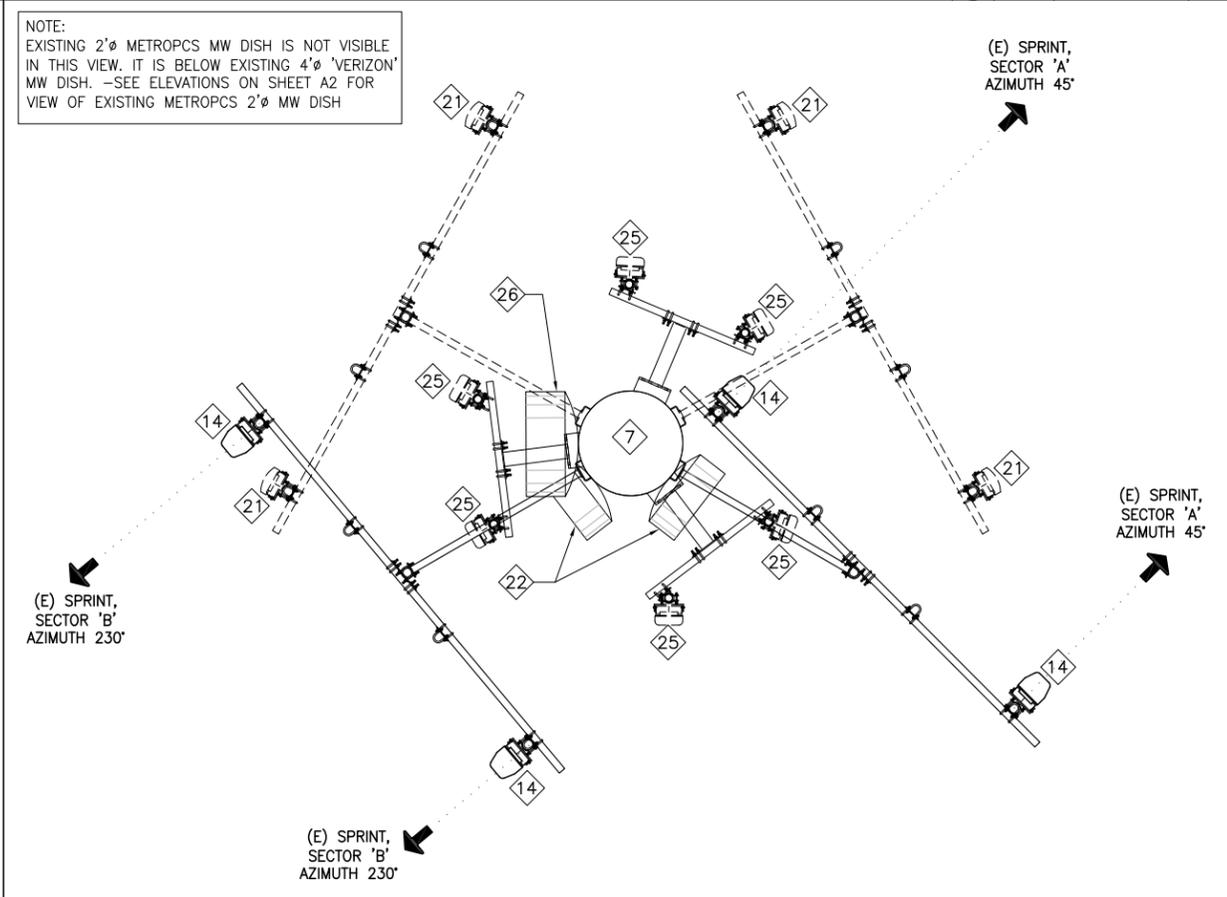

EXISTING / PROPOSED EQUIPMENT LAYOUT PLAN

SCALE: 1/4"=1'-0" 3

EXISTING / PROPOSED ANTENNA LAYOUT PLAN

SCALE: 1/2"=1'-0" 2

APPROVALS:

APPROVED BY:	INITIALS:	DATE:
LANDLORD		
LEASING		
ZONING		
RF		
CM		

DRAWN BY:	CHK:	APV:
IP	BOK	DKD

ISSUE STATUS:

△ DATE:	DESCRIPTION:	BY:
01/16/12	90% ZD	IP
02/20/12	100% ZD	IP
06/14/12	METROPCS FACILITY ADDED	JGD
06/25/12	REV PER METROPCS COMMENT	JGD


SHEET TITLE:
**OVERALL SITE PLAN,
EXISTING/PROPOSED
EQUIPMENT & ANTENNA
LAYOUT PLAN**

SHEET NUMBER:
A1

ISSUE LEVEL:
QUAIL LAKE
878021

- 1 (E) 'SPRINT' ANTENNAS, 2 PER SECTOR
- 2 (E) 'SPRINT' VACANT PIPE MOUNT
- 3 (E) 'VERIZON' ANTENNAS
- 4 (E) 4'Ø 'VERIZON' MICROWAVE DISH
- 5 (E) ±102'-0" HIGH MONOPOLE
- 6 (E) MONOPOLE CABLE SHROUD
- 7 (E) 'SPRINT' GPS ANTENNA
- 8 (E) ±8'-0" CHAINLINK FENCE
- 9 (E) SERVICE LIGHT (4 TOTAL)
- 10 (E) 'VERIZON' EQUIPMENT CABINET
- 11 PROPOSED 'METROPCS'/'VERIZON' METER/MAIN
- 12 (E) 'VERIZON' GENERATOR
- 13 (E) 'SPRINT' EQUIPMENT
- 14 PROPOSED 'METROPCS'/'VERIZON' UTILITY RACK
- 15 PROPOSED 'METROPCS' EQUIPMENT CABINETS
- 16 (E) 'SPRINT' EGR/PPC & TELCO RACK
- 17 PROPOSED 9'-0" WIDE GATE
- 18 (E) 'VERIZON' GPS ANTENNA
- 19 PROPOSED 'METROPCS' ANTENNAS, 2 PER SECTOR, 6 TOTAL
- 20 PROPOSED 'METROPCS' 2'Ø MICROWAVE DISH, 2 TOAL
- 21 (E) 2'Ø 'METROPCS' MICROWAVE DISH

KEYNOTES

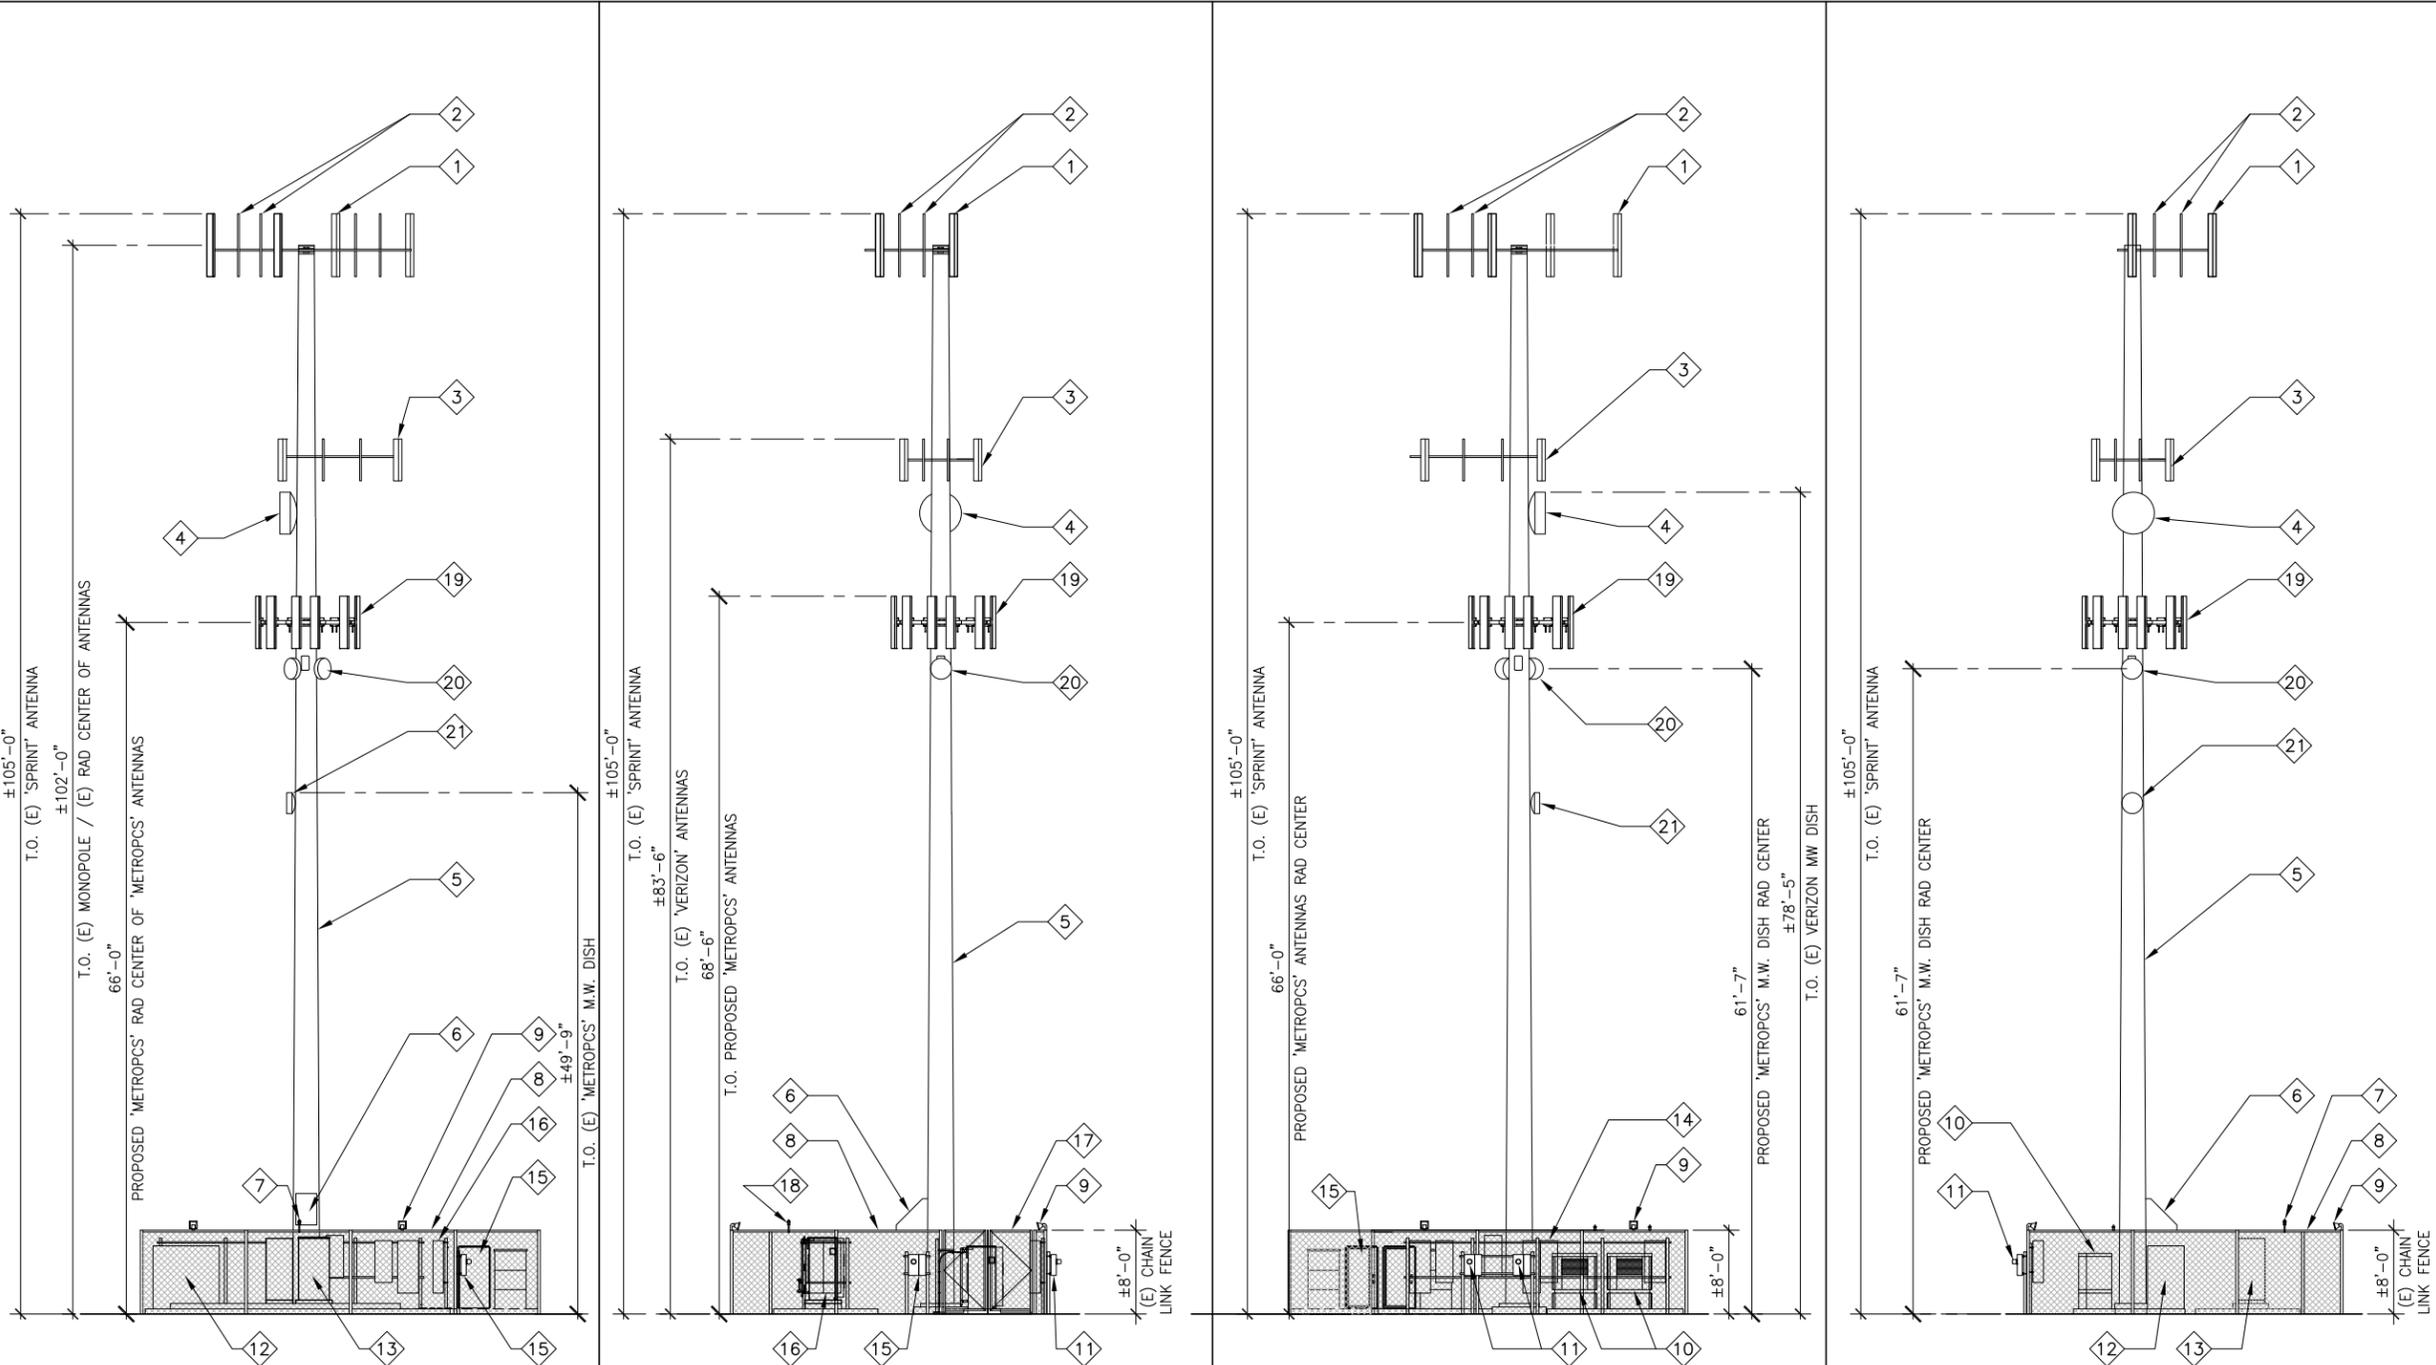

SOUTH ELEVATION

SCALE: 1/8"=1'-0"
0 2' 4' 8'

EAST ELEVATION

SCALE: 1/8"=1'-0"
0 2' 4' 8'

NORTH ELEVATION

SCALE: 1/8"=1'-0"
0 2' 4' 8'

WEST ELEVATION

SCALE: 1/8"=1'-0"
0 2' 4' 8'

DCI PACIFIC
A|E|C WORKS

ARCHITECTURE | ENGINEERING | CONSULTING
32 EXECUTIVE PARK | SUITE 110 | IRVINE | CA 92614
T 949 475.1000 | 949 475.1001 F



PROJECT IDENTIFICATION:

QUAIL LAKE
878021

33700 W. LANCASTER ROAD,
GORMAN, CA 93536

CURRENT ISSUE DATE:

06/25/12

ISSUED FOR:

RENEWAL

APPROVALS:

APPROVED BY:	INITIALS:	DATE:
LANDLORD		
LEASING		
ZONING		
RF		
CM		

DRAWN BY:	CHK:	APV:
IP	BOK	DKD

ISSUE STATUS:

Δ DATE:	DESCRIPTION:	BY:
01/16/12	90% ZD	IP
02/20/12	100% ZD	IP
06/14/12	METROPCS FACILITY ADDED	JGD
06/25/12	REV PER METROPCS COMMENT	JGD

SHEET TITLE:

ELEVATIONS

SHEET NUMBER:

A2

ISSUE LEVEL:

QUAIL LAKE
878021

