

PROPRIETARY INFORMATION
 THE INFORMATION CONTAINED IN THIS SET OF CONSTRUCTION DOCUMENTS IS PROPRIETARY BY NATURE. ANY USE OR DISCLOSURE OTHER THAN THAT WHICH RELATES TO VERIZON WIRELESS IS STRICTLY PROHIBITED.

SITE NAME:
NEVERS
 (ADDRESS PENDING)
 S/S AMAR RD., 230'± W/O EVANWOOD AVE.
 (UNINCORPORATED) LA PUENTE, CA 91744

C.E.S. PROJECT NO.:
10010394-15

CITY LOG#:

STAMP:
PRELIMINARY CD

SITE INFORMATION:
 ISSUE DATE: 11-19-12
 ENGINEERED BY: C.E.S.
 DRAFTED BY: C.E.S.



PLANS PREPARED BY:
CeS cable engineering services
 PRESCOTT COMMUNICATIONS INC.
 10640 Sepulveda Blvd. Suite 1, Mission Hills, CA 91345
 Phone No.: (818)898-2352 Fax No.: (818)898-9186

REVISIONS:			DATE	BY
1	11-21-12	PRELIMINARY		

SHEET TITLE:
ENLARGED SITE PLAN

SHEET NUMBER:
5 OF 14
 C.E.S. DWG. NO. ATC12068

SCE CONTRACTOR TO REPLACE
 EXIST. 50'-0" (43'-0" AGL) WOOD POLE #E16617Y WITH A 55'-0" (47'-6" AGL) WOOD POLE #E16617Y AND PLACE (6) PANEL ANTENNAS ON (2)-12' OFFSET CROSS ARMS. (VZW SITE POLE)


VERIZON WIRELESS CONTRACTOR TO PLACE
 (1)-24"x21"x8" CONC. PAD (FLUSH WITH EXIST. CONC. SIDEWALK) WITH (1)-20"x17"x48" MYERS ELECTRICAL METER PEDESTAL.

VERIZON WIRELESS CONTRACTOR TO REMOVE & REPLACE
 EXIST. CURB & GUTTER FROM SCORE LINE TO SCORE LINE FOR PLACEMENT OF EQUIPMENT VAULT.

VERIZON WIRELESS CONTRACTOR TO PLACE
 (1)-7'-1.5"x25'-1.5"x16'-6.25"(d) (CEMH 624-9) CONTROLLED ENVIRONMENT MANHOLE.

NOTE:
 ADDITIONAL EXCAVATION REQUIRED FOR SHORING EQUIPMENT.

VERIZON WIRELESS CONTRACTOR TO PLACE
 (2)-21.25" DIA.x42" TALL VENTILATION STACKS.

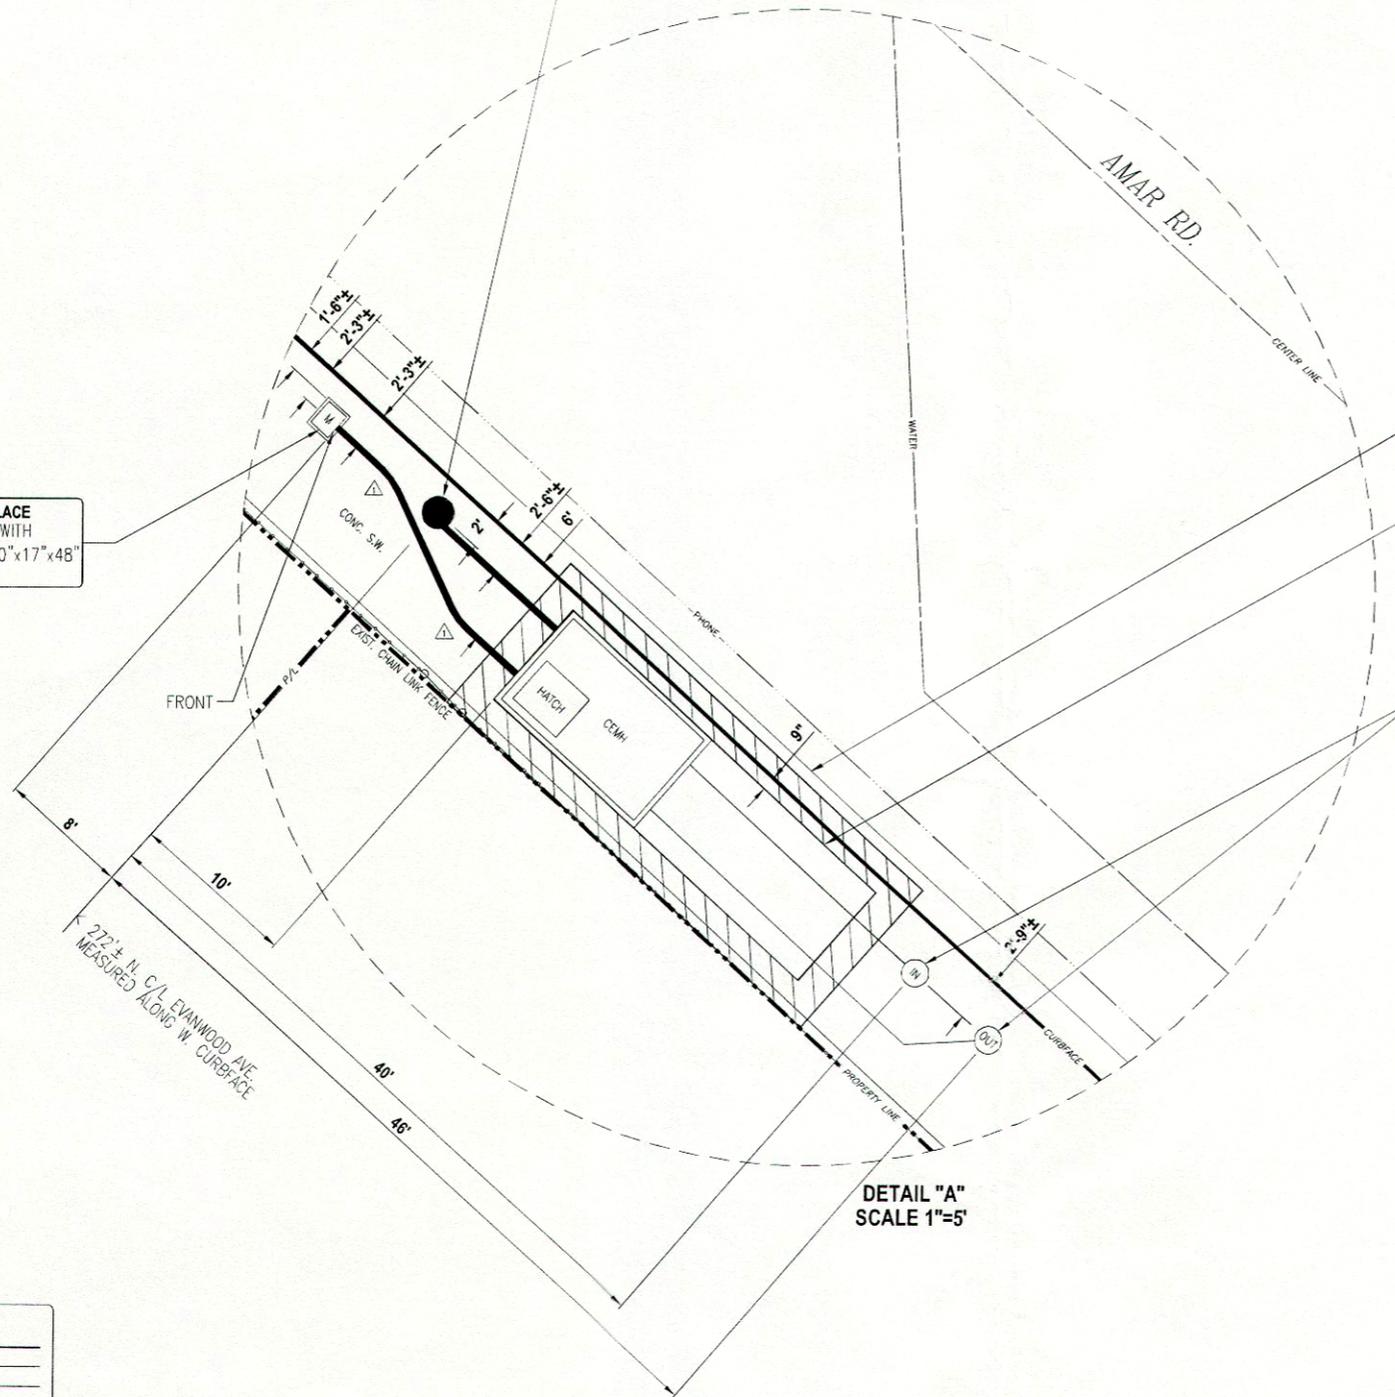

DETAIL "A"
 SCALE 1"=5'



UTILITY LINE TYPE LEGEND:

PROPOSED CONDUIT	---
POWER	---
GAS	---
WATER	---
PHONE	---
STREET LIGHT	---
OIL	---
SEWER	---
CABLE TV	---
STORM DRAIN	---

CONDUIT CURVE DATA

R = 4'-0"	△
R = 22'-0"	△
L = 1'-7"	△



ENLARGED SITE PLAN

SCALE:
 1"=5' 1