

- NOTES:**
- IT SHALL BE THE CONTRACTOR'S RESPONSIBILITY TO COORDINATE WITH THE PROPERTY OWNER & NECESSARY UTILITY COMPANIES FOR THE LOCATION OF ALL EXISTING BELOW GRADE UTILITIES PRIOR TO BEGINNING CONSTRUCTION. CONTRACTOR SHALL BE RESPONSIBLE FOR ANY DAMAGE COSTS ASSOCIATED WITH EXISTING BELOW GRADE UTILITIES.
  - CONTRACTOR TO COORDINATE WITH UTILITY COMPANY FOR CONNECTION OF TEMPORARY AND PERMANENT POWER TO THE SITE. THE TEMPORARY POWER AND ALL HOOKUP COSTS TO BE PAID BY CONTRACTOR.
  - CONTRACTOR TO VERIFY LOCAL UTILITY REQUIREMENTS FOR DEPTH, SIZE & SEPARATION OF CONDUITS PRIOR TO INSTALLATION. NOTIFY CONSTRUCTION MANAGER IMMEDIATELY OF ANY DISCREPANCIES.
  - CONTRACTOR TO CALL DIG ALERT (800)-227-2600 A MINIMUM OF 48 HRS PRIOR TO EXCAVATING FOR UNDERGROUND UTILITY LOCATIONS. CONTRACTOR IS RESPONSIBLE TO HAVE ALL NONPUBLIC UTILITIES LOCATED AT THEIR OWN EXPENSE.
  - PROPOSED UTILITY SERVICES SHOWN NEED TO BE VERIFIED & APPROVED BY UTILITY COMPANIES BEFORE START OF CONSTRUCTION. CONTRACTOR TO VERIFY WITH CLIENT PROJECT MANAGER TO OBTAIN FINAL APPROVAL.
  - CONTRACTOR TO VERIFY SERVICE LOCATIONS w/ACTUAL FIELD CONDITIONS.
  - CONTRACTOR SHALL IMMEDIATELY INFORM CLIENT OF ANY ACCIDENTAL DAMAGE TO EXISTING UTILITIES BY TELEPHONE AND E-MAIL REGARDLESS OF ABILITY TO REPAIR OR MITIGATE. A FOLLOW-UP E-MAIL REPORT WITH DIGITAL PHOTOS WILL BE REQUIRED DAILY UNTIL RESOLUTION HAS BEEN ACCEPTED BY CLIENT AND AFFECTED SERVICE PROVIDERS AND RECIPIENTS. AT THEIR OWN EXPENSE, CONTRACTOR WILL EXERCISE ALL EFFORTS TO HAVE REPAIRS MADE BY QUALIFIED TECHNICIANS AS APPROVED BY SERVICE PROVIDER.

**NOTE:**  
IT SHALL BE THE RESPONSIBILITY OF EITHER CLIENT OR THE SITE CONTRACTOR TO ORDER THE PROPER VAULT FROM THE MANUFACTURER MATCHING THE CONDUIT PORT LAYOUTS AS SHOWN ON THESE PLANS. THE VAULT WILL BE CUSTOM MADE BY THE MANUFACTURER UPON RECEIPT OF A PURCHASE ORDER.

ITEM #	DESCRIPTION
1	19'-0" MYERS ELECTRICAL METER PEDESTAL TO CEMH 624-9 1-2" SCH. 40 PVC CONDUIT (VZW PWR.)
2	10'-0" CEMH 624-9 TO SITE POLE 3-4" SCH. 40 PVC CONDUITS (VZW COMM.)

**SCE CONTRACTOR TO REPLACE**  
EXIST. 50'-0" (43'-0" AGL) WOOD POLE #E16617Y WITH A 55'-0" (47'-6" AGL) WOOD POLE #E16617Y AND PLACE (6) PANEL ANTENNAS ON (2)-12' OFFSET CROSS ARWS. (VZW SITE POLE)

**VERIZON WIRELESS CONTRACTOR TO REMOVE & REPLACE**  
EXIST. CURB & GUTTER FROM SCORE LINE TO SCORE LINE FOR PLACEMENT OF EQUIPMENT VAULT.

**VERIZON WIRELESS CONTRACTOR TO PLACE**  
(1)-7'-1.5"x25'-1.5"x16'-6.25"(d) (CEMH 624-9) CONTROLLED ENVIRONMENT MANHOLE.

**NOTE:**  
ADDITIONAL EXCAVATION REQUIRED FOR SHORING EQUIPMENT.

**VERIZON WIRELESS CONTRACTOR TO PLACE**  
(1)-24"x21"x8" CONC. PAD (FLUSH WITH EXIST. CONC. SIDEWALK) WITH (1)-20"x17"x48" MYERS ELECTRICAL METER PEDESTAL.

**VERIZON WIRELESS CONTRACTOR TO PLACE**  
(2)-21.25" DIA.x42" TALL VENTILATION STACKS.

**EXIST. POLE #4758768E**  
**POSSIBLE POWER & TELCO SOURCE**  
**NOTE:**  
EXACT SOURCE OF FEED AND ROUTING TO BE PROVIDED UPON COMPLETION OF POWER & TELCO MEET.



**UTILITY LINE TYPE LEGEND:**

---	PROPOSED CONDUIT
---	POWER
---	GAS
---	WATER
---	PHONE
---	STREET LIGHT
---	OIL
---	SEWER
---	CABLE TV
---	STORM DRAIN



**UNDERGROUND UTILITIES NOTE:**  
THE LOCATIONS AND EXISTENCE OF ANY UNDERGROUND PIPES, STRUCTURES OR CONDUITS SHOWN ON THIS PLAN WERE OBTAINED BY A SEARCH OF AVAILABLE RECORDS. THERE MAY BE EXIST. UTILITIES OTHER THAN THOSE SHOWN ON THIS PLAN. THE CONTRACTOR IS REQUIRED TO TAKE PRECAUTIONARY MEASURES TO PROTECT THE UTILITY LINES SHOWN AND ANY OTHER LINES NOT SHOWN ON THIS PLAN.

**CONDUIT CURVE DATA**

P	= 4'-0"
R	= 22'-0"
L	= 1'-7"

**CITY OF LA PUENTE PERMIT INFORMATION**

HDD / OPEN TRENCH A/C FOOTAGE:	0'-0"
HDD / OPEN TRENCH CONCRETE FOOTAGE:	29'-0"
HDD / OPEN TRENCH GRASS/DIRT FOOTAGE:	0'-0"
HDD / OPEN TRENCH TOTAL PROJECT FOOTAGE:	29'-0"

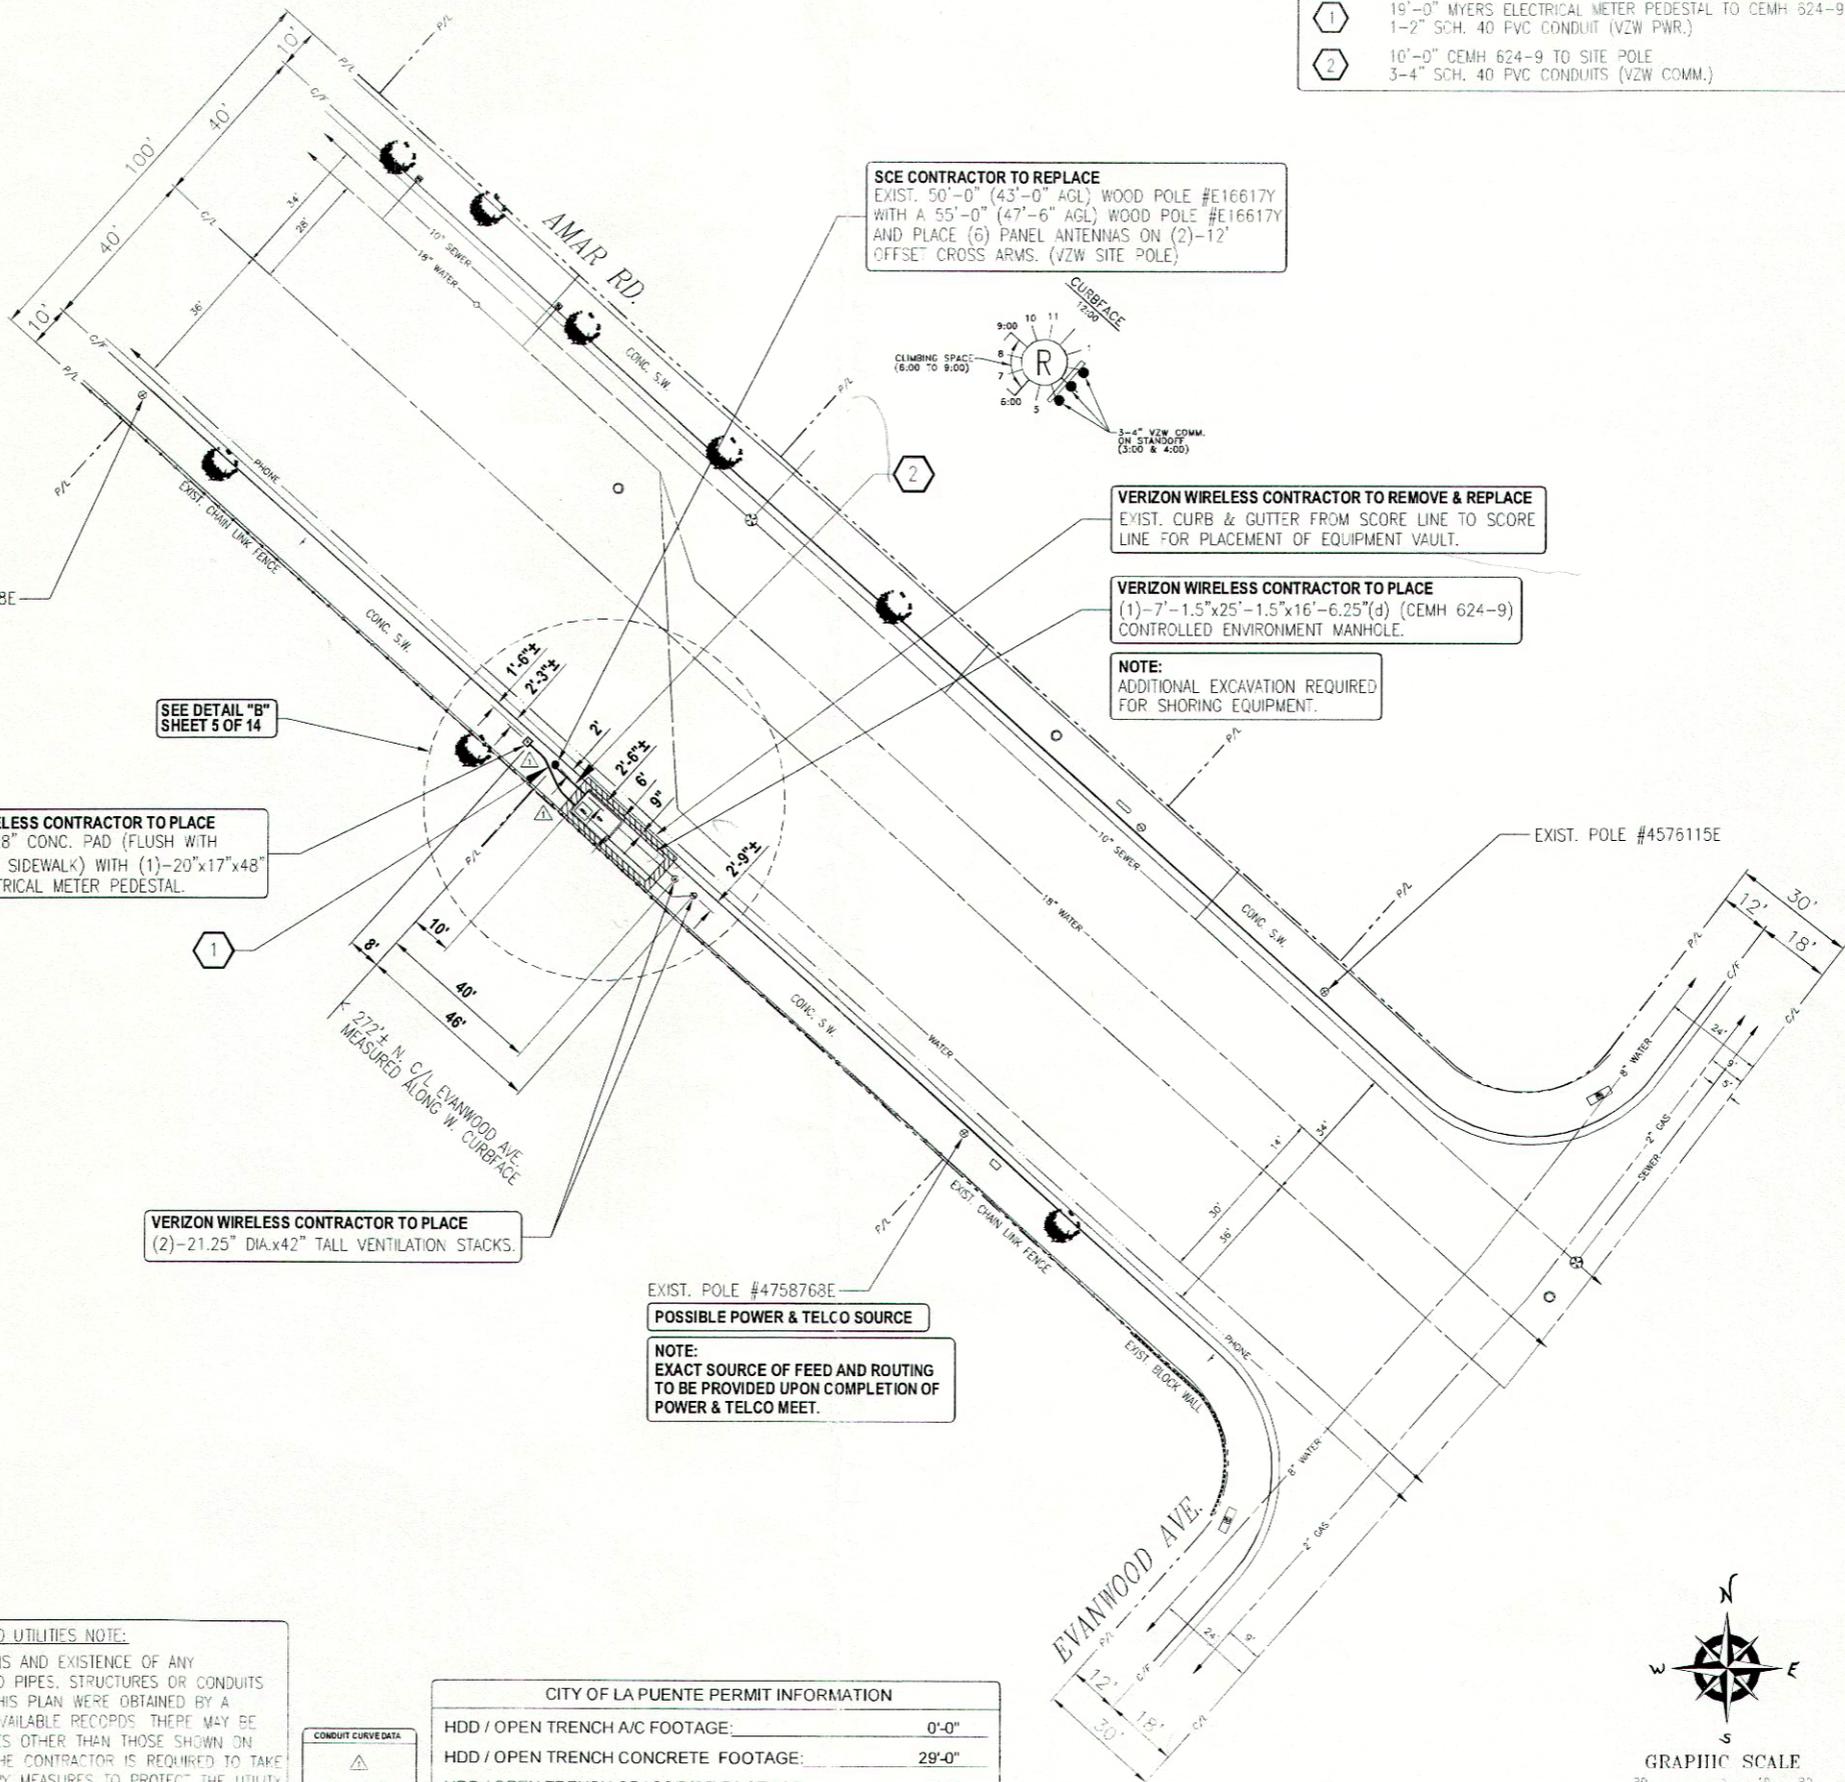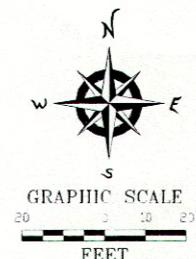

**PROPRIETARY INFORMATION**  
THE INFORMATION CONTAINED IN THIS SET OF CONSTRUCTION DOCUMENTS IS PROPRIETARY BY NATURE. ANY USE OR DISCLOSURE OTHER THAN THAT WHICH RELATES TO VERIZON WIRELESS IS STRICTLY PROHIBITED.

**SITE NAME:**  
**NEVERS**  
(ADDRESS PENDING)  
S/S AMAR RD., 230 1/2 W/O EVANWOOD AVE.  
(UNINCORPORATED) LA PUENTE, CA 91744

**C.E.S. PROJECT NO.:**  
**10010394-15**

**CITY LOG#:**

**STAMP:**  
**PRELIMINARY CD**

**SITE INFORMATION:**  
**ISSUE DATE:** 11-19-12  
**ENGINEERED BY:** C.E.S.  
**DRAFTED BY:** C.E.S.



**PLANS PREPARED BY:**  
**CeS cable engineering services**  
PRESCOTT COMMUNICATIONS INC.  
10640 Sepulveda Blvd. Suite 1, Mission Hills, CA 91345  
Phone No.: (818)998-2352 Fax No.: (818)998-9186

**REVISIONS:**

NO.	DATE	DESCRIPTION	DRAWN	CHECKED
1	11-21-12	PRELIMINARY	JM	TL

**SHEET TITLE:**  
**SITE PLAN**

**SHEET NUMBER:**  
**4 OF 14**  
C.E.S. DWG. NO. ATC12068